



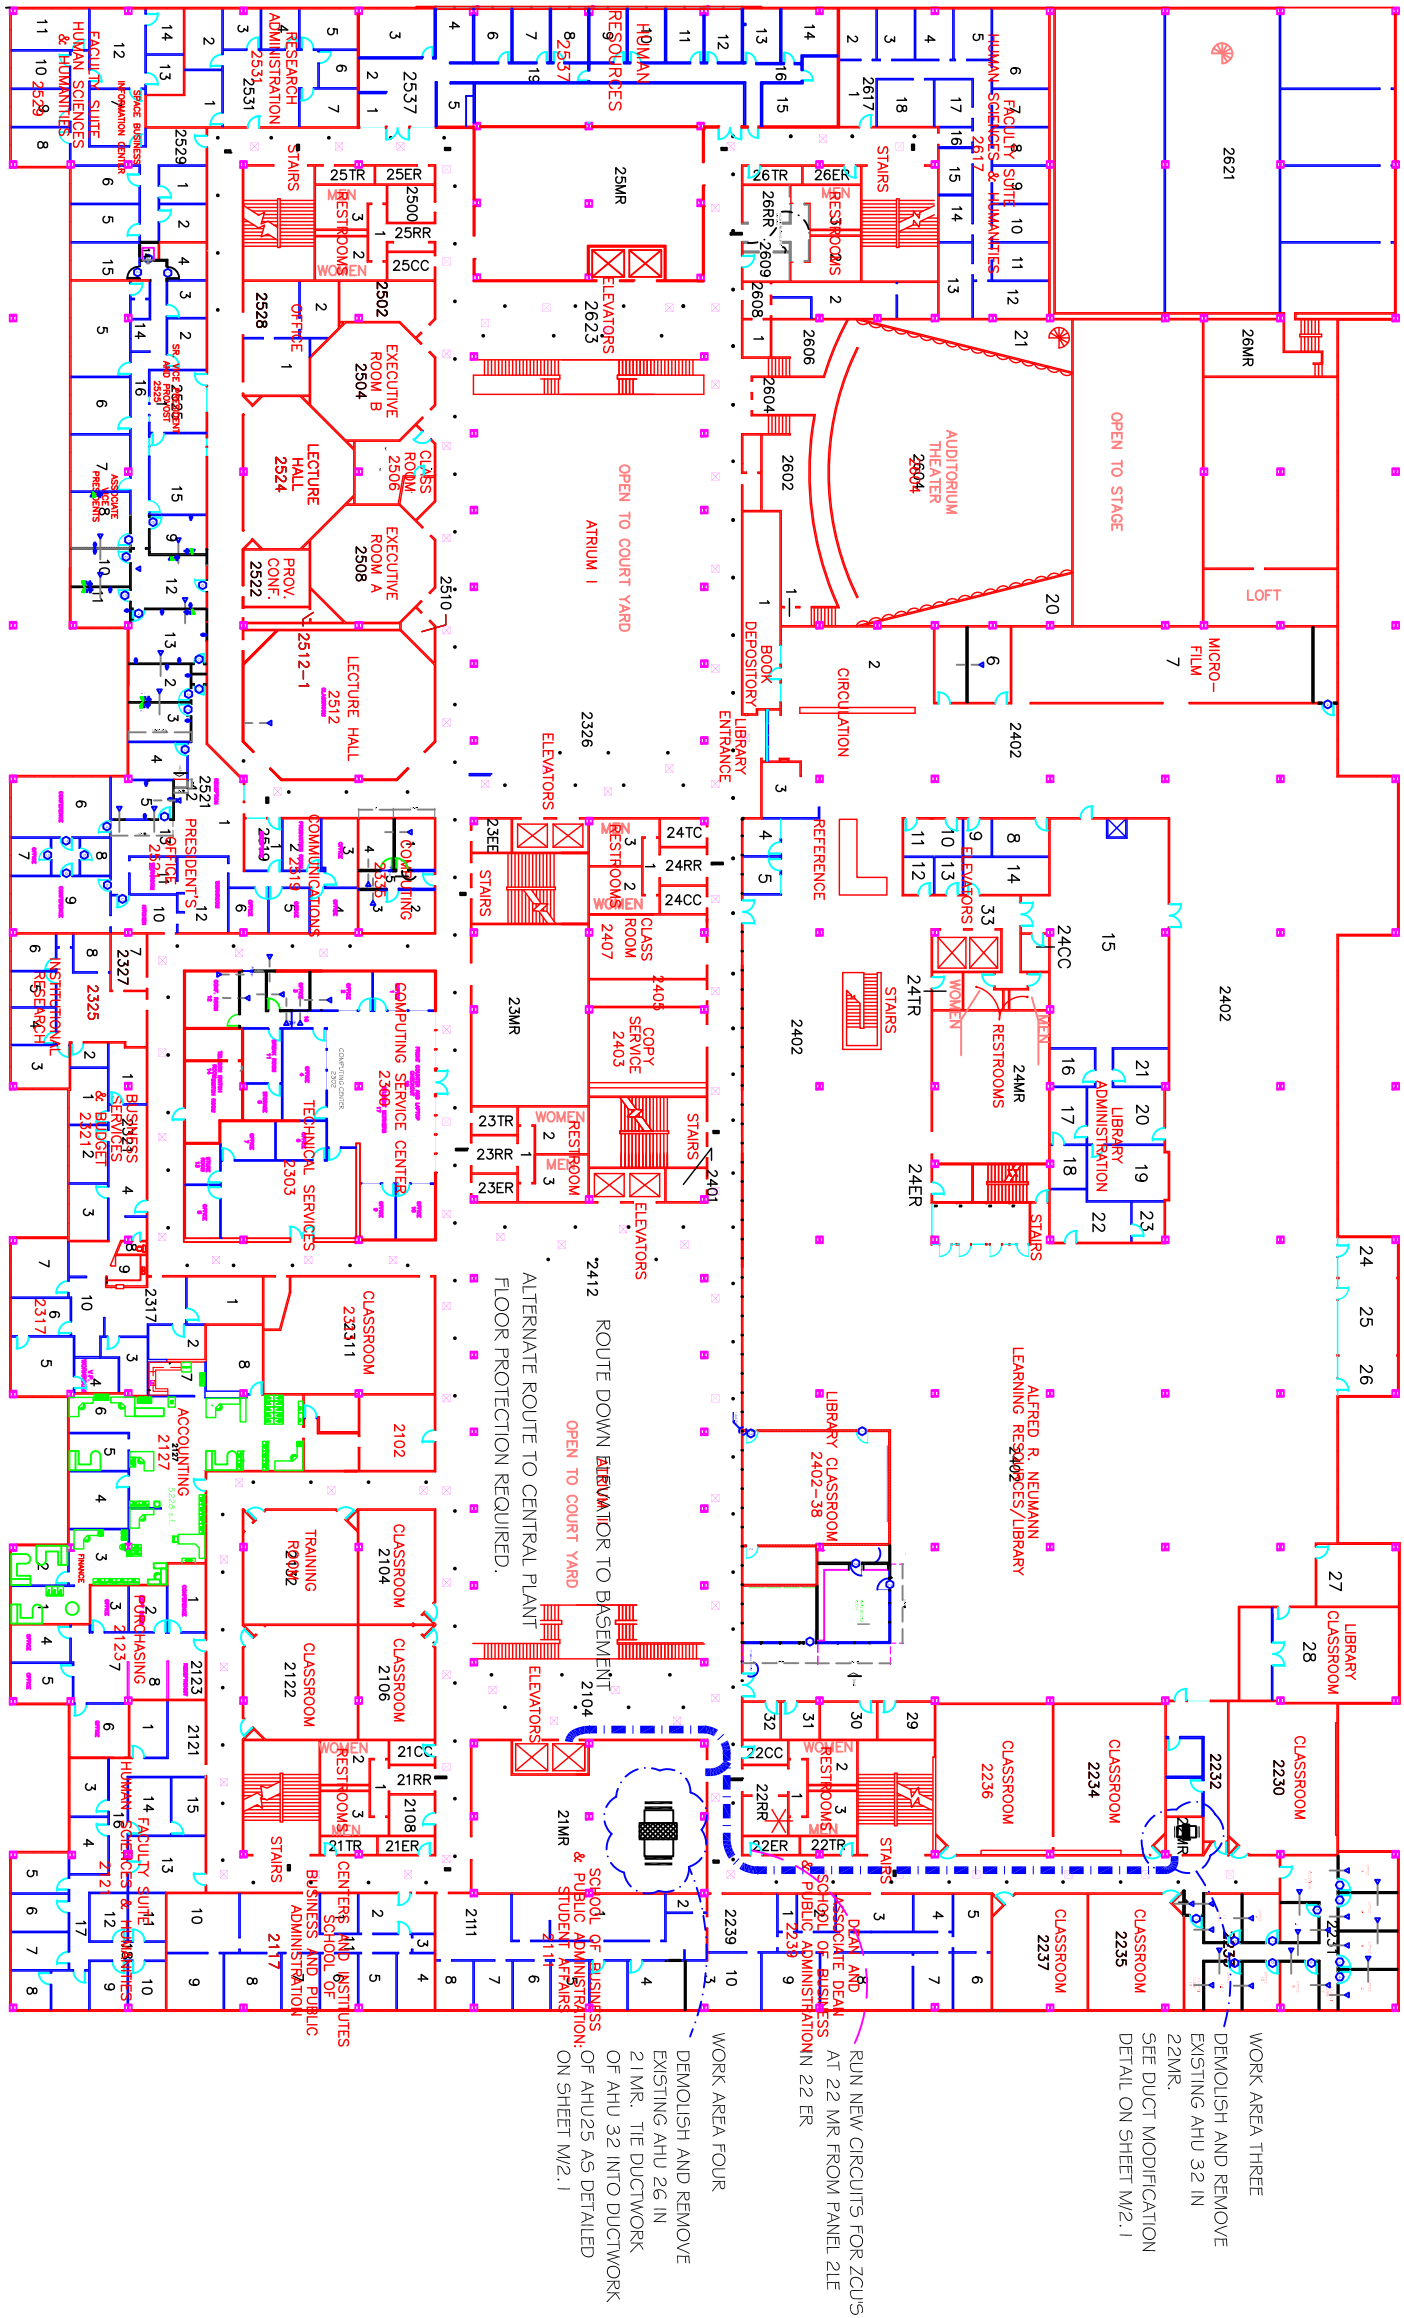

BAYOU BUILDING SECOND FLOOR

AIR HANDLER UNIT NUMBER AND LOCATION
SEE SPECIFICATION FOR DETAILS, REQUIREMENTS
SUGGESTED ROUTE FOR REMOVAL AND INSTALLATION

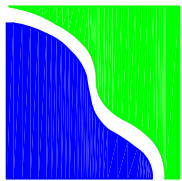

University
of Houston
Clear Lake
Facilities Management
and Construction

DRAWN BY D.G.W.
CHECKED BY D.G.W.
Scale: 1" = 50'
DATE 10/25/11

BAYOU BUILDING SECOND FLOOR
FISCAL YEAR 2012
AIR HANDLER REPLACEMENT
22 MR DUCTWORK DETAILS

M/1.2