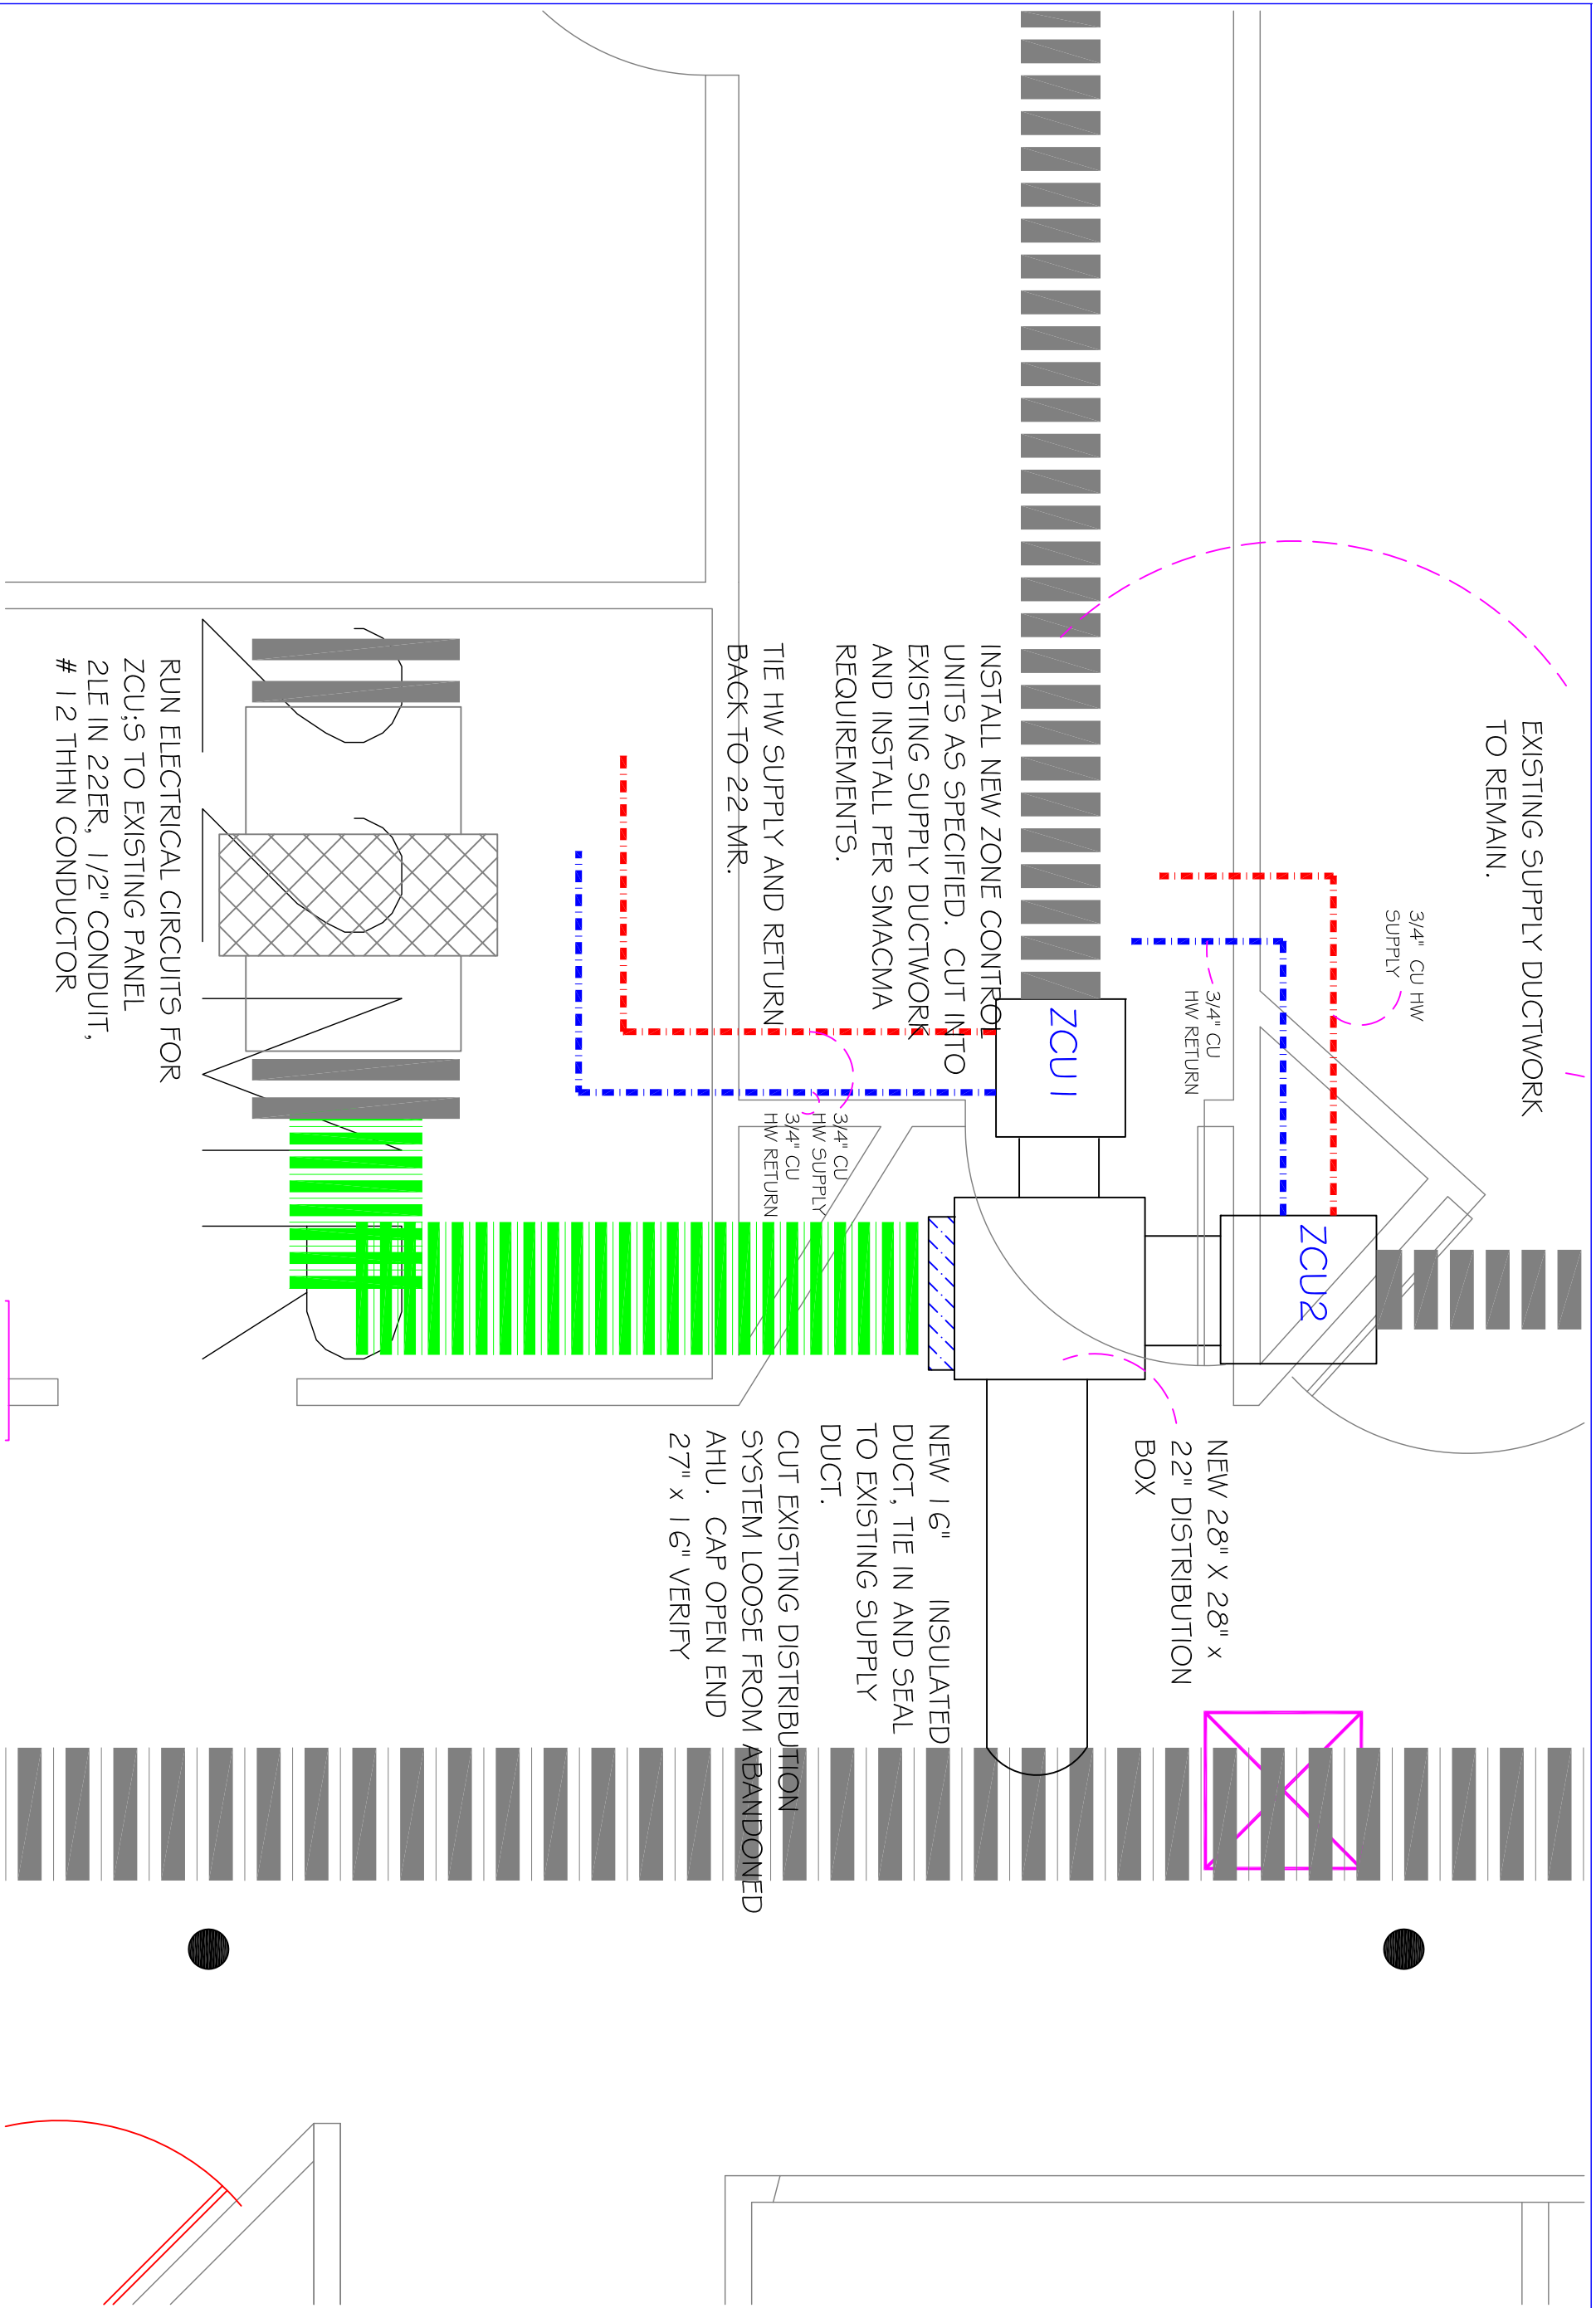


University
of Houston
Clear Lake

Facilities Management
and Construction

DRAWN BY D.G.W.

CHECKED BY D.G.W.

Scale: 1/2" = 1'=0"

DATE 10/25/11

BAYOU BUILDING SECOND FLOOR

FISCAL YEAR 2012

AIR HANDLER REPLACEMENT

22 MR DUCTWORK DETAILS

M/2.2