


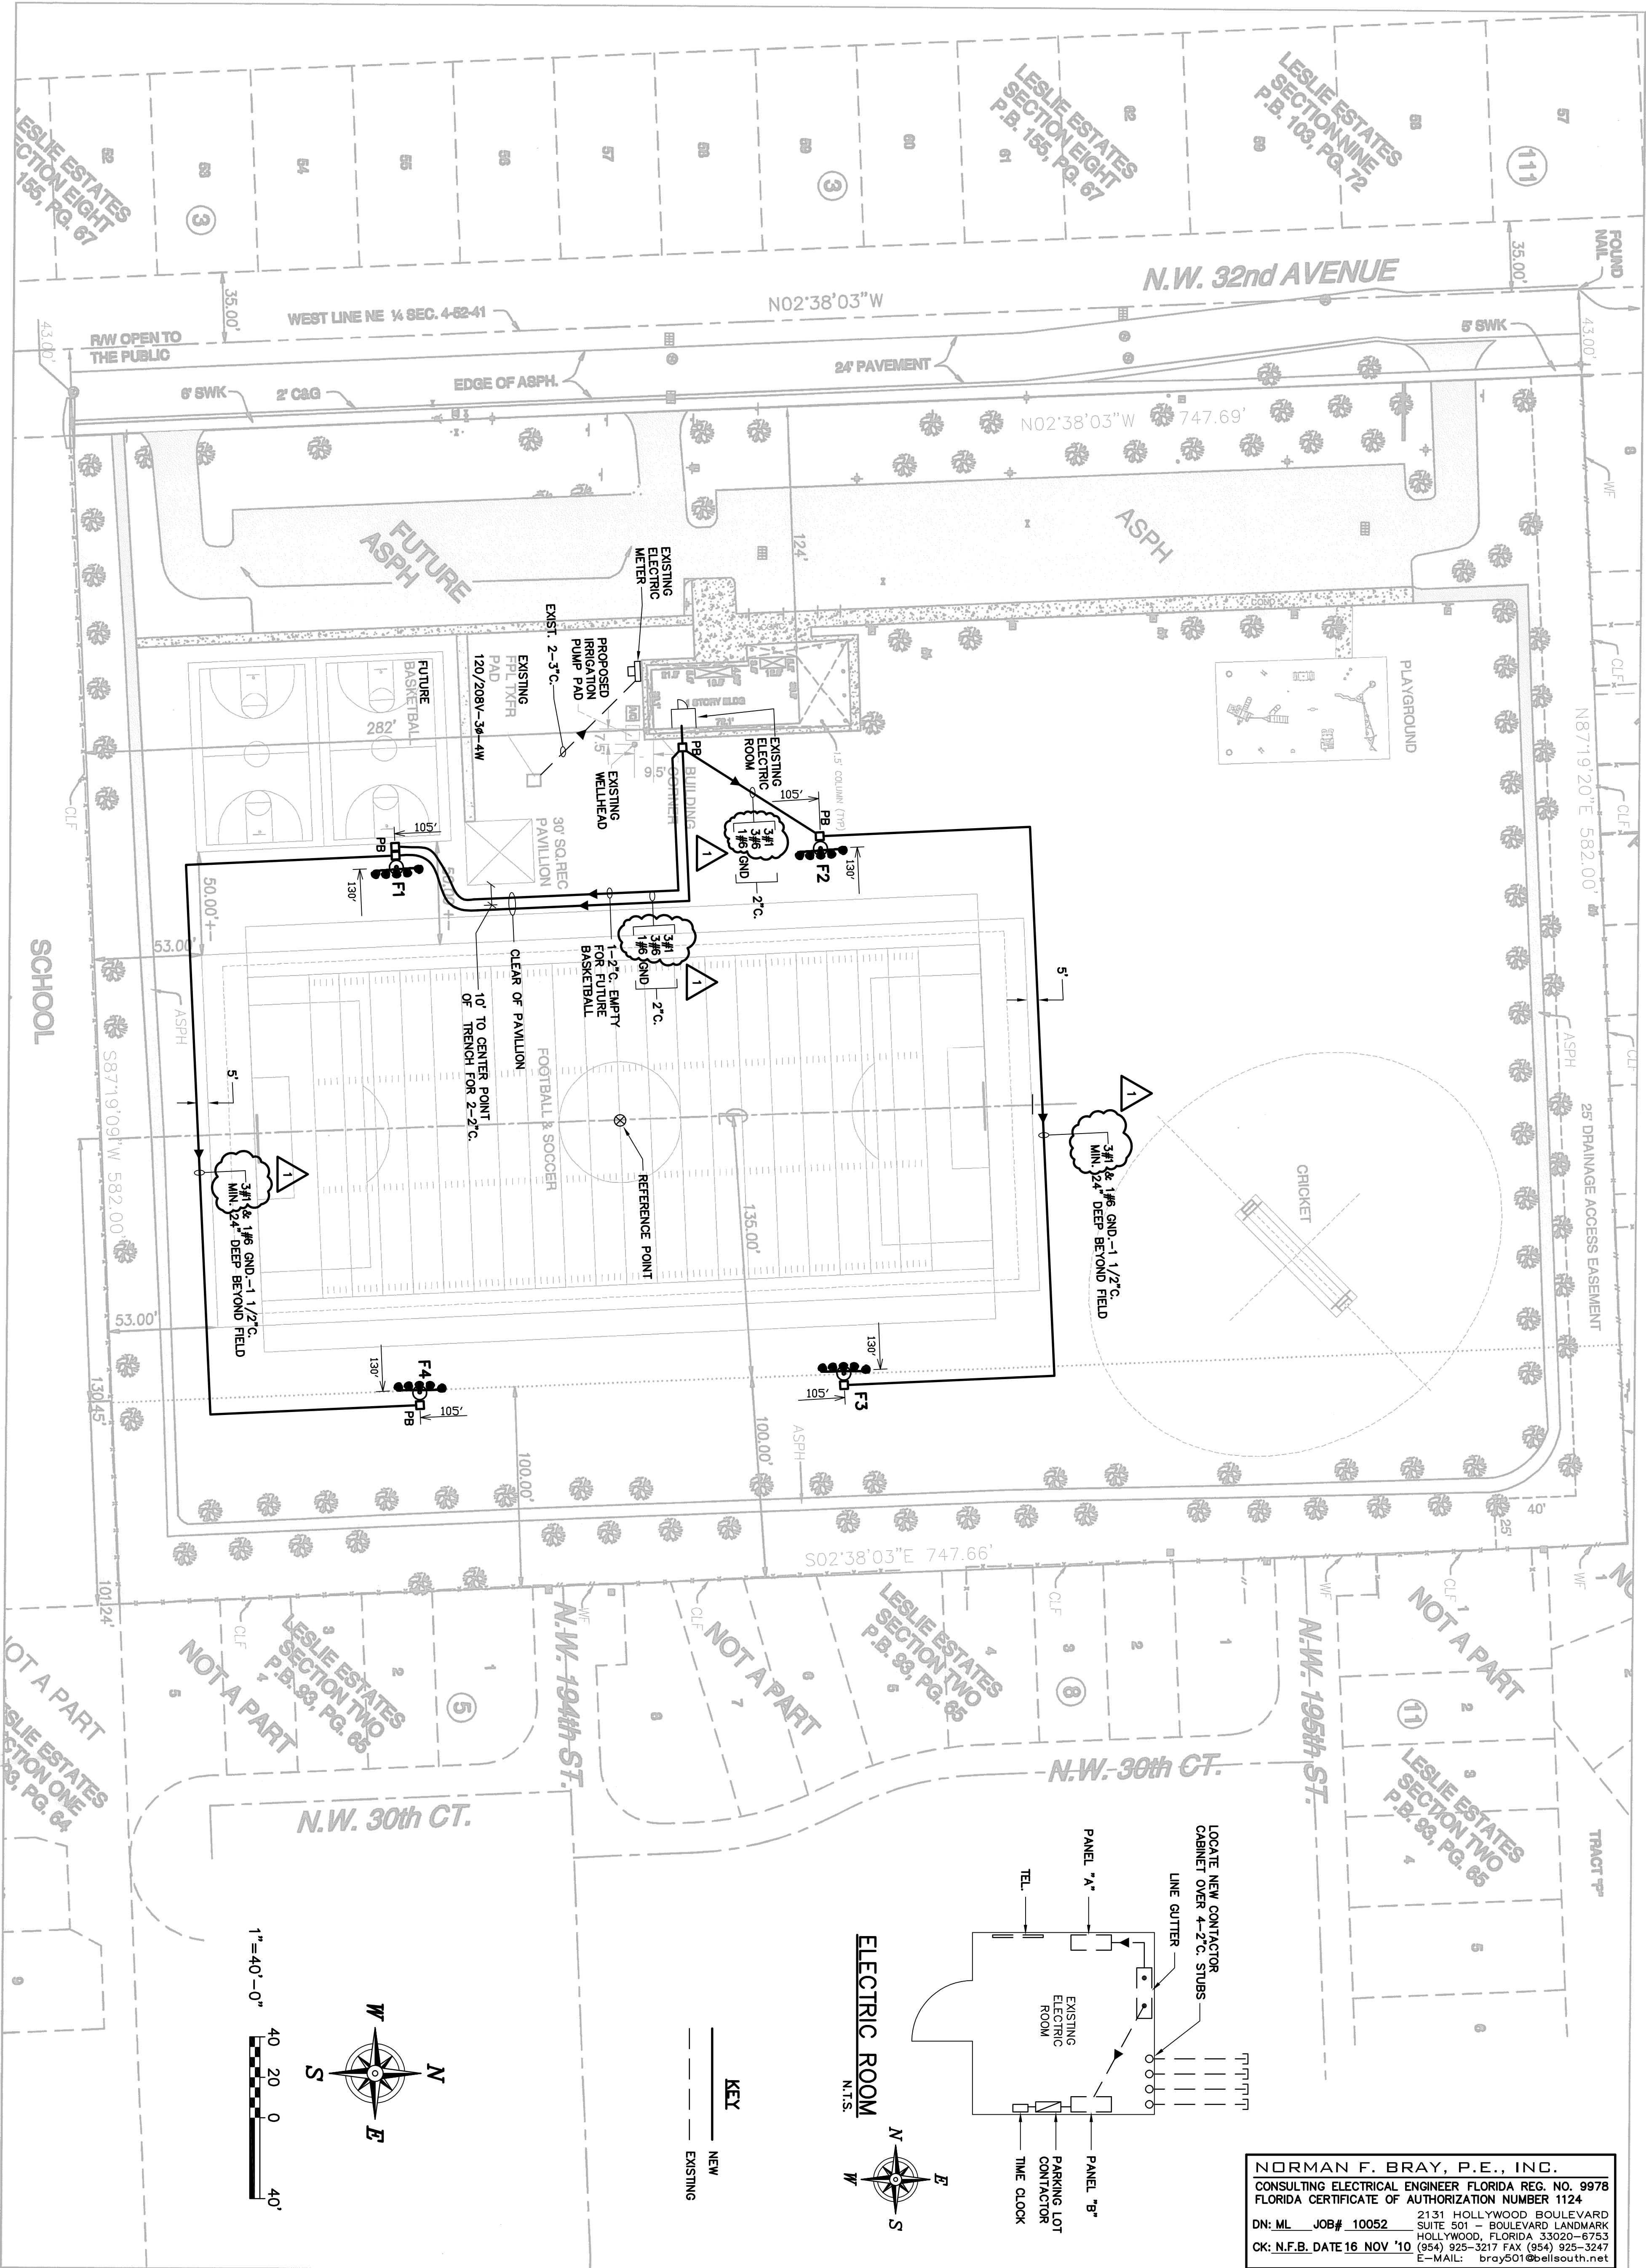

NORMAN F. BRAY, P.E., INC.
CONSULTING ELECTRICAL ENGINEER FLORIDA REG. NO. 9978
FLORIDA CERTIFICATE OF AUTHORIZATION NUMBER 1124
DN: ML JOB# 10052 2131 HOLLYWOOD BOULEVARD SUITE 501 - BOULEVARD LANDMARK HOLLYWOOD, FLORIDA 33020-6753 (954) 925-3217 FAX (954) 925-3247
CK: N.F.B. DATE 16 NOV '10 E-MAIL: bray501@bellsouth.net

Revisions		
N°	Date	Description
1	11/23/10	PER COMMENTS

Design:
Drawn:
Checked:
Survey:
Inspection:
Proj. Mgr:

**BRENTWOOD PARK
SITE PLAN**

Project Title:
**THE CITY OF MIAMI GARDENS
19405 N.W. 32nd AVENUE**
Drawing Title:

Project No:
Date:
Scale:
Drawing No:
E-1 of 2
Drawn:
Dwg.: