

THESE RECORD DRAWINGS HAVE BEEN PREPARED BASED ON INFORMATION PROVIDED BY OTHERS. THE CONSULTANT HAS NOT VERIFIED THE ACCURACY AND/OR COMPLETENESS OF THIS INFORMATION AND SHALL NOT BE RESPONSIBLE FOR ANY ERRORS OR OMISSIONS THAT MAY BE INCORPORATED AS A RESULT OF ERRONEOUS INFORMATION PROVIDED BY OTHERS.

© Copyright 2007 The LKA Partners, Inc. This document and the information contained herein may not be reproduced or excerpted from without the express written permission of The LKA Partners, Inc. Unauthorized copying, disclosure or construction use are prohibited by copyright law.

**Falcon High
School #3**
New School Address
Falcon, Colorado 80831

RECORD DOCUMENTS



These Record Documents have been prepared based on information (marked-up prints, drawings and other data) provided to the Architect by the Contractor. The Architect has not verified the accuracy and/or completeness of this information and shall not be responsible for the errors or omissions which may be incorporated herein as a result.



Falcon School District 49
10850 E. Woodmen Road
Falcon, Colorado 80831
Record Documents

Drawn:	CBW, RLM, GDC
Checked:	
Issued:	April 16, 2007
Revised:	December 30, 2008

Area Key Plan

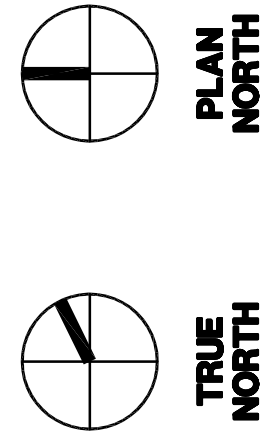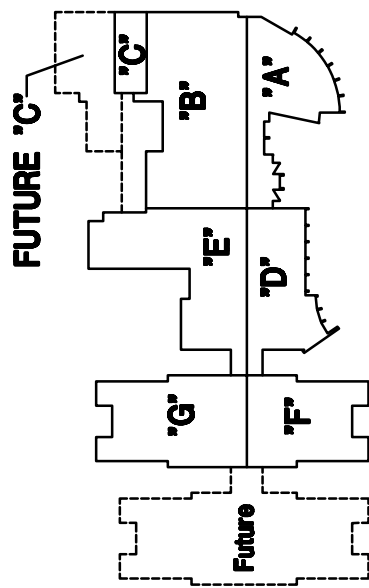

ELECTRICAL SITE PLAN

SCALE: AS NOTED


Office

New Falcon High School Project No. 05-023
The LKA Partners Incorporated

ELECTRICAL LEGEND

[illegible]

ELECTRICAL LINEWEIGHT LEGEND	
ALL ELECTRICAL SYMBOLS SHOWN WITHIN THIS CATEGORY ARE TO REMAIN.	EXISTING DUPLEX EXISTING SWITCH EXISTING OUTLET EXISTING YOUR EXISTING TO REMAIN TYPICAL EXAMPLES Ⓢ
ALL ELECTRICAL SYMBOLS SHOWN WITHIN THIS CATEGORY ARE TO BE REMOVED.	EXISTING DUPLEX EXISTING SWITCH EXISTING OUTLET EXISTING TO BE REMOVED TYPICAL EXAMPLES Ⓢ
ALL ELECTRICAL SYMBOLS SHOWN WITHIN THIS CATEGORY ARE NEW DEVICES.	NEW DUPLEX NEW SWITCH NEW OUTLET TYPICAL EXAMPLES Ⓢ

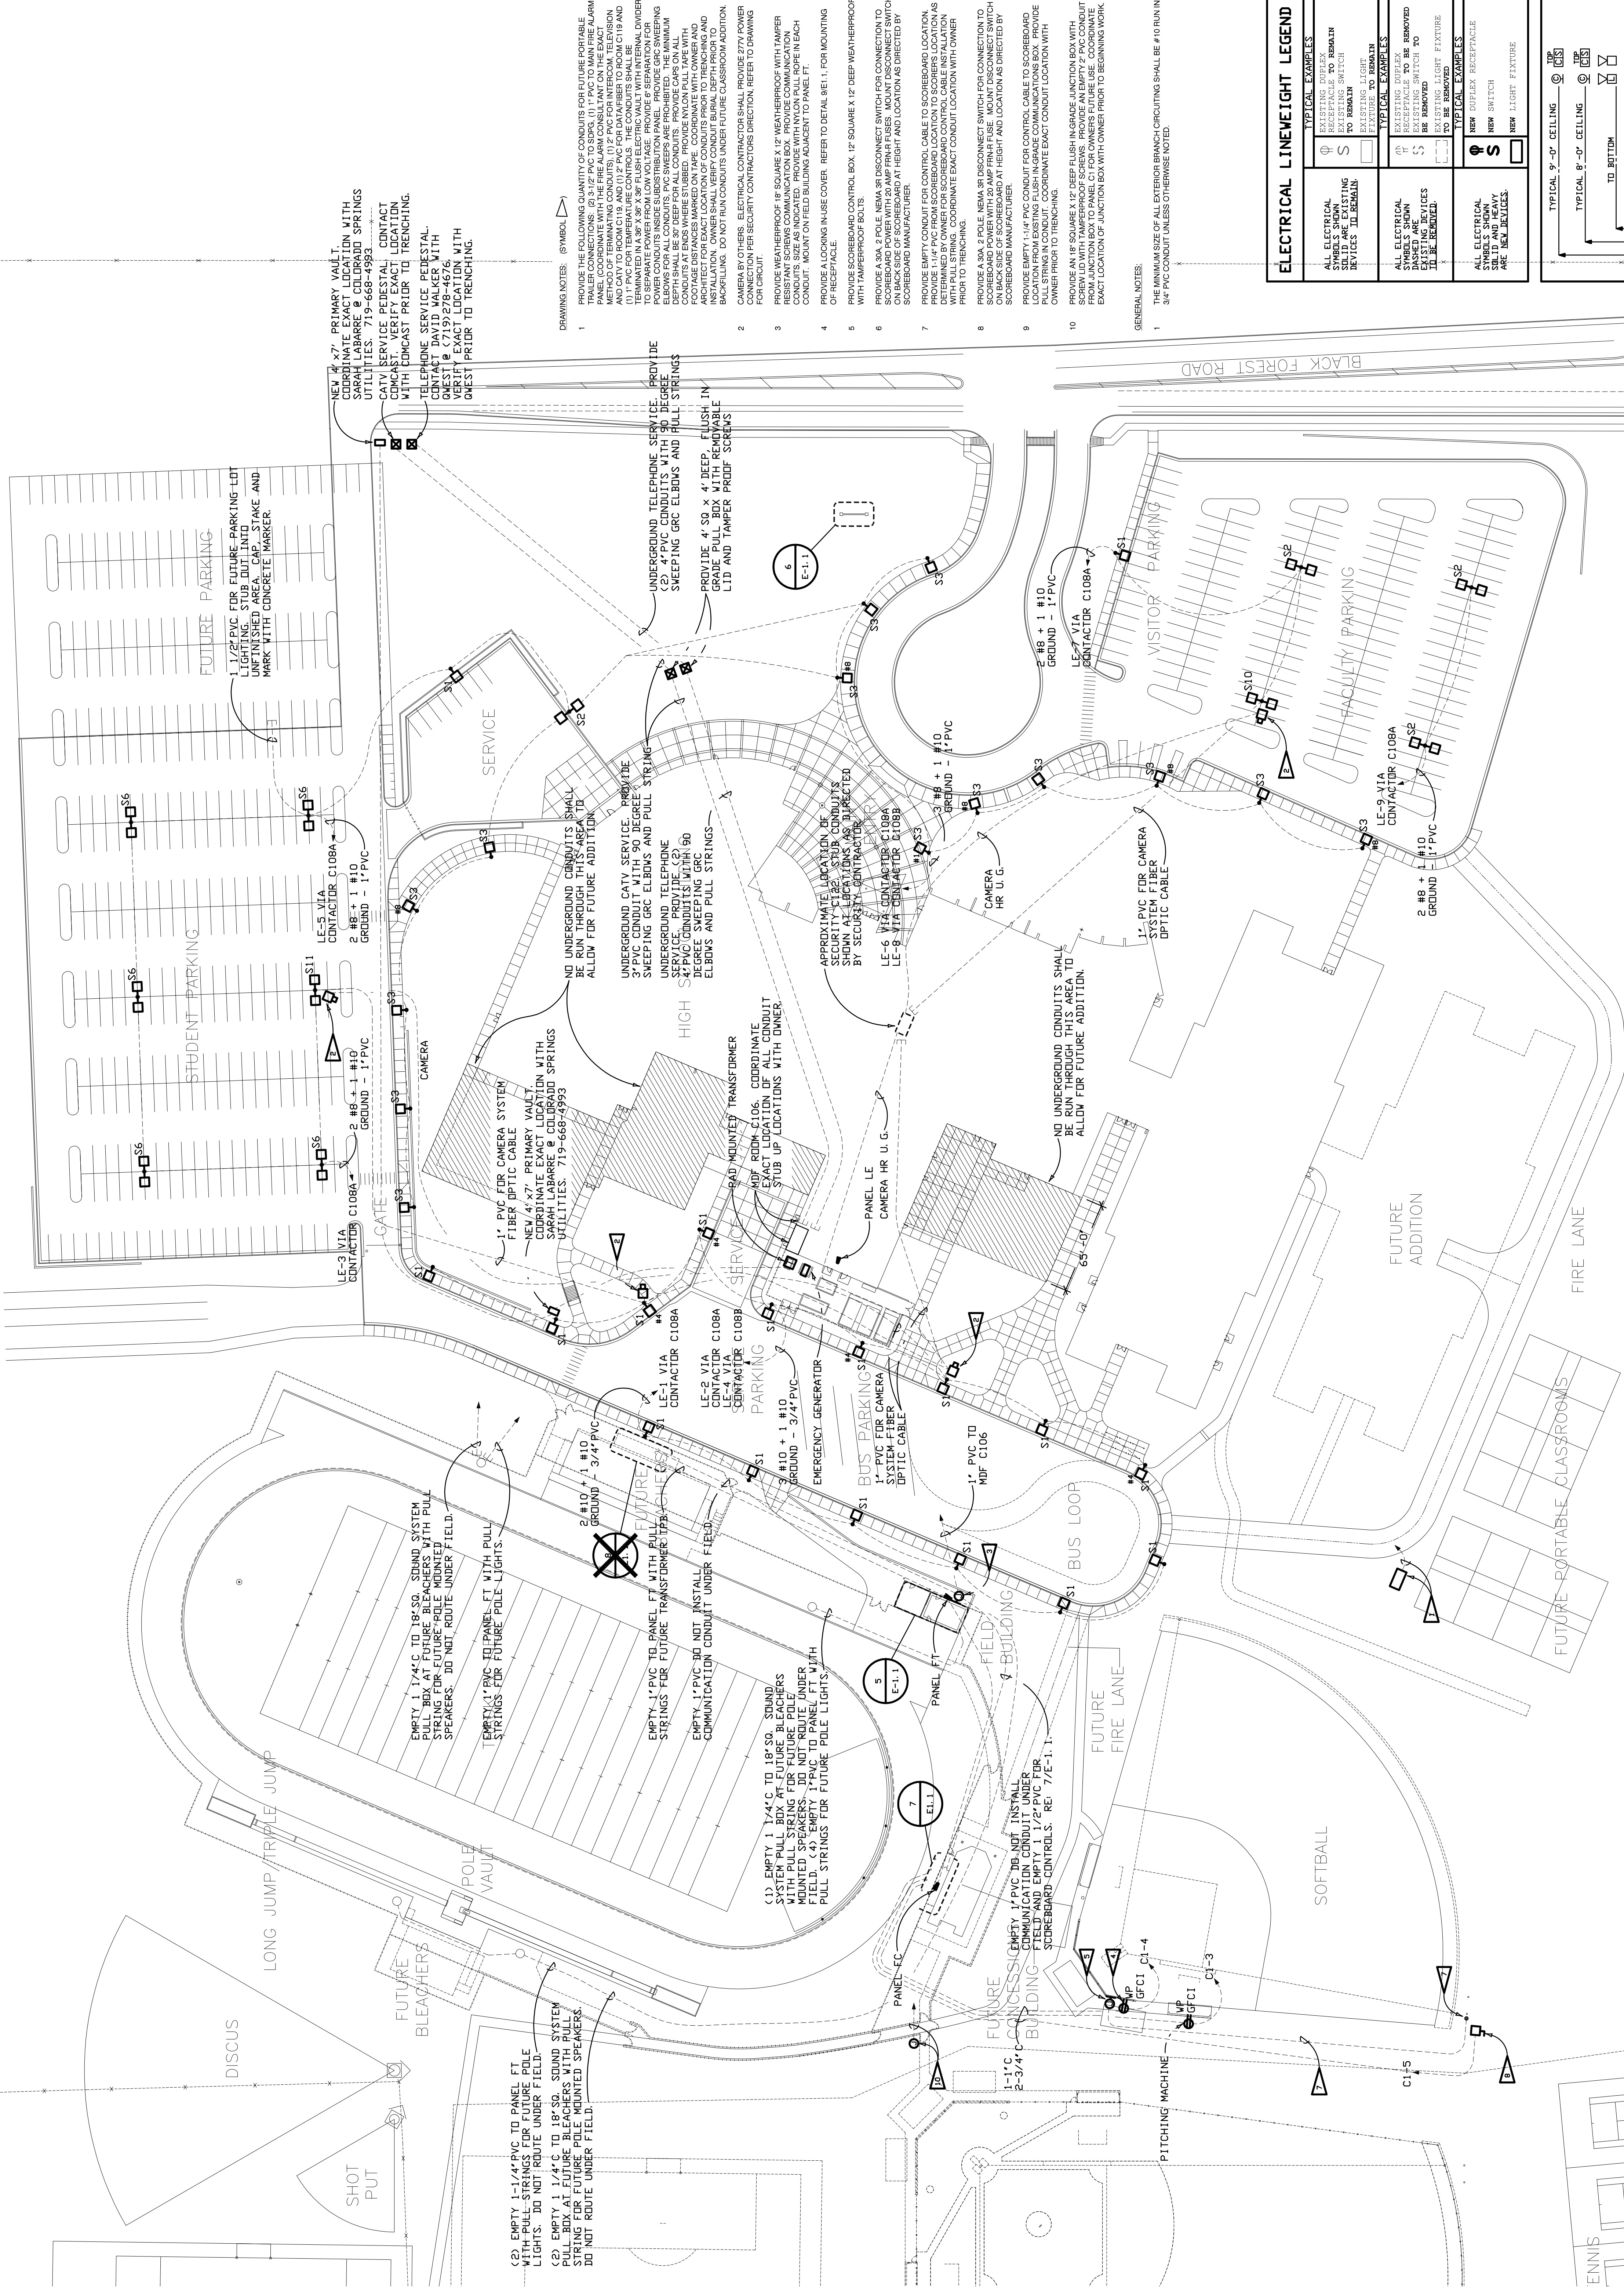

THE INTENT OF THIS SITE PLAN IS TO SHOW NEW TELEPHONE, CATV AND ELECTRICAL UNDERGROUND SYSTEMS TO BE INSTALLED UNDER THIS CONTRACT. REFER TO CIVIL ENGINEERING DRAWINGS FOR EXACT LOCATION OF EXISTING UTILITIES, INCLUDING: TELEPHONE, CATV, GAS, WATER, SEWER, UNDERGROUND OR OVERHEAD ELECTRIC LINES, EXISTING PRIMARY VAULTS AND PAD MOUNTED TRANSFORMERS.

THE ELECTRICAL DRAWINGS DO NOT REFLECT ANY EXISTING ELECTRICAL UTILITY INFORMATION. SINCE THE ENGINEER HAS NOT BEEN IN DIRECT CHARGE OF PRODUCING THIS INFORMATION,

1 ELECTRICAL SITE PLAN

SCALE: 1" = 50'-0"