


Falcon High School No. 3
6888 Black Forest Road
Colorado Springs, Colorado 80922

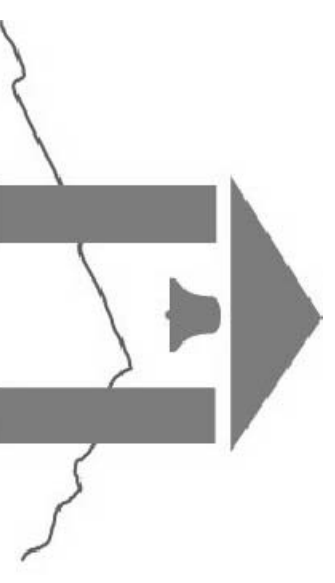


FALCON
SCHOOL DISTRICT 49
A Special Place for Everyone
Falcon School District 49
10850 E. Woodmen Road
Falcon, Colorado 80831

AS-BUILTS

Drawn: RDE
Checked: WRH
Issued: January 5, 2009
Revised:

Area Key Plan

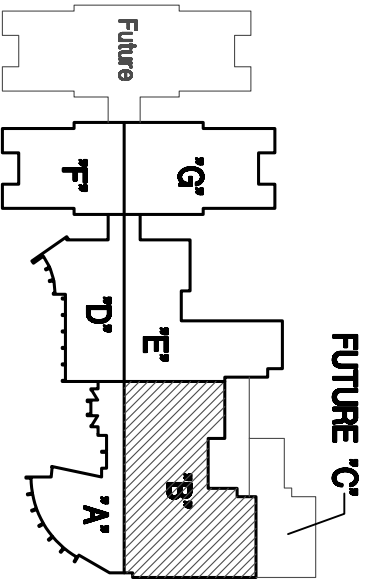


TRUE NORTH
PLAN NORTH

MAIN LEVEL FLOOR PLAN
AREA "B" - HYDRONIC
Scale 1/8" = 1'-0"

M-3.2

Falcon High School No. 3 Project No. 06-023
The LKA Partners Incorporated

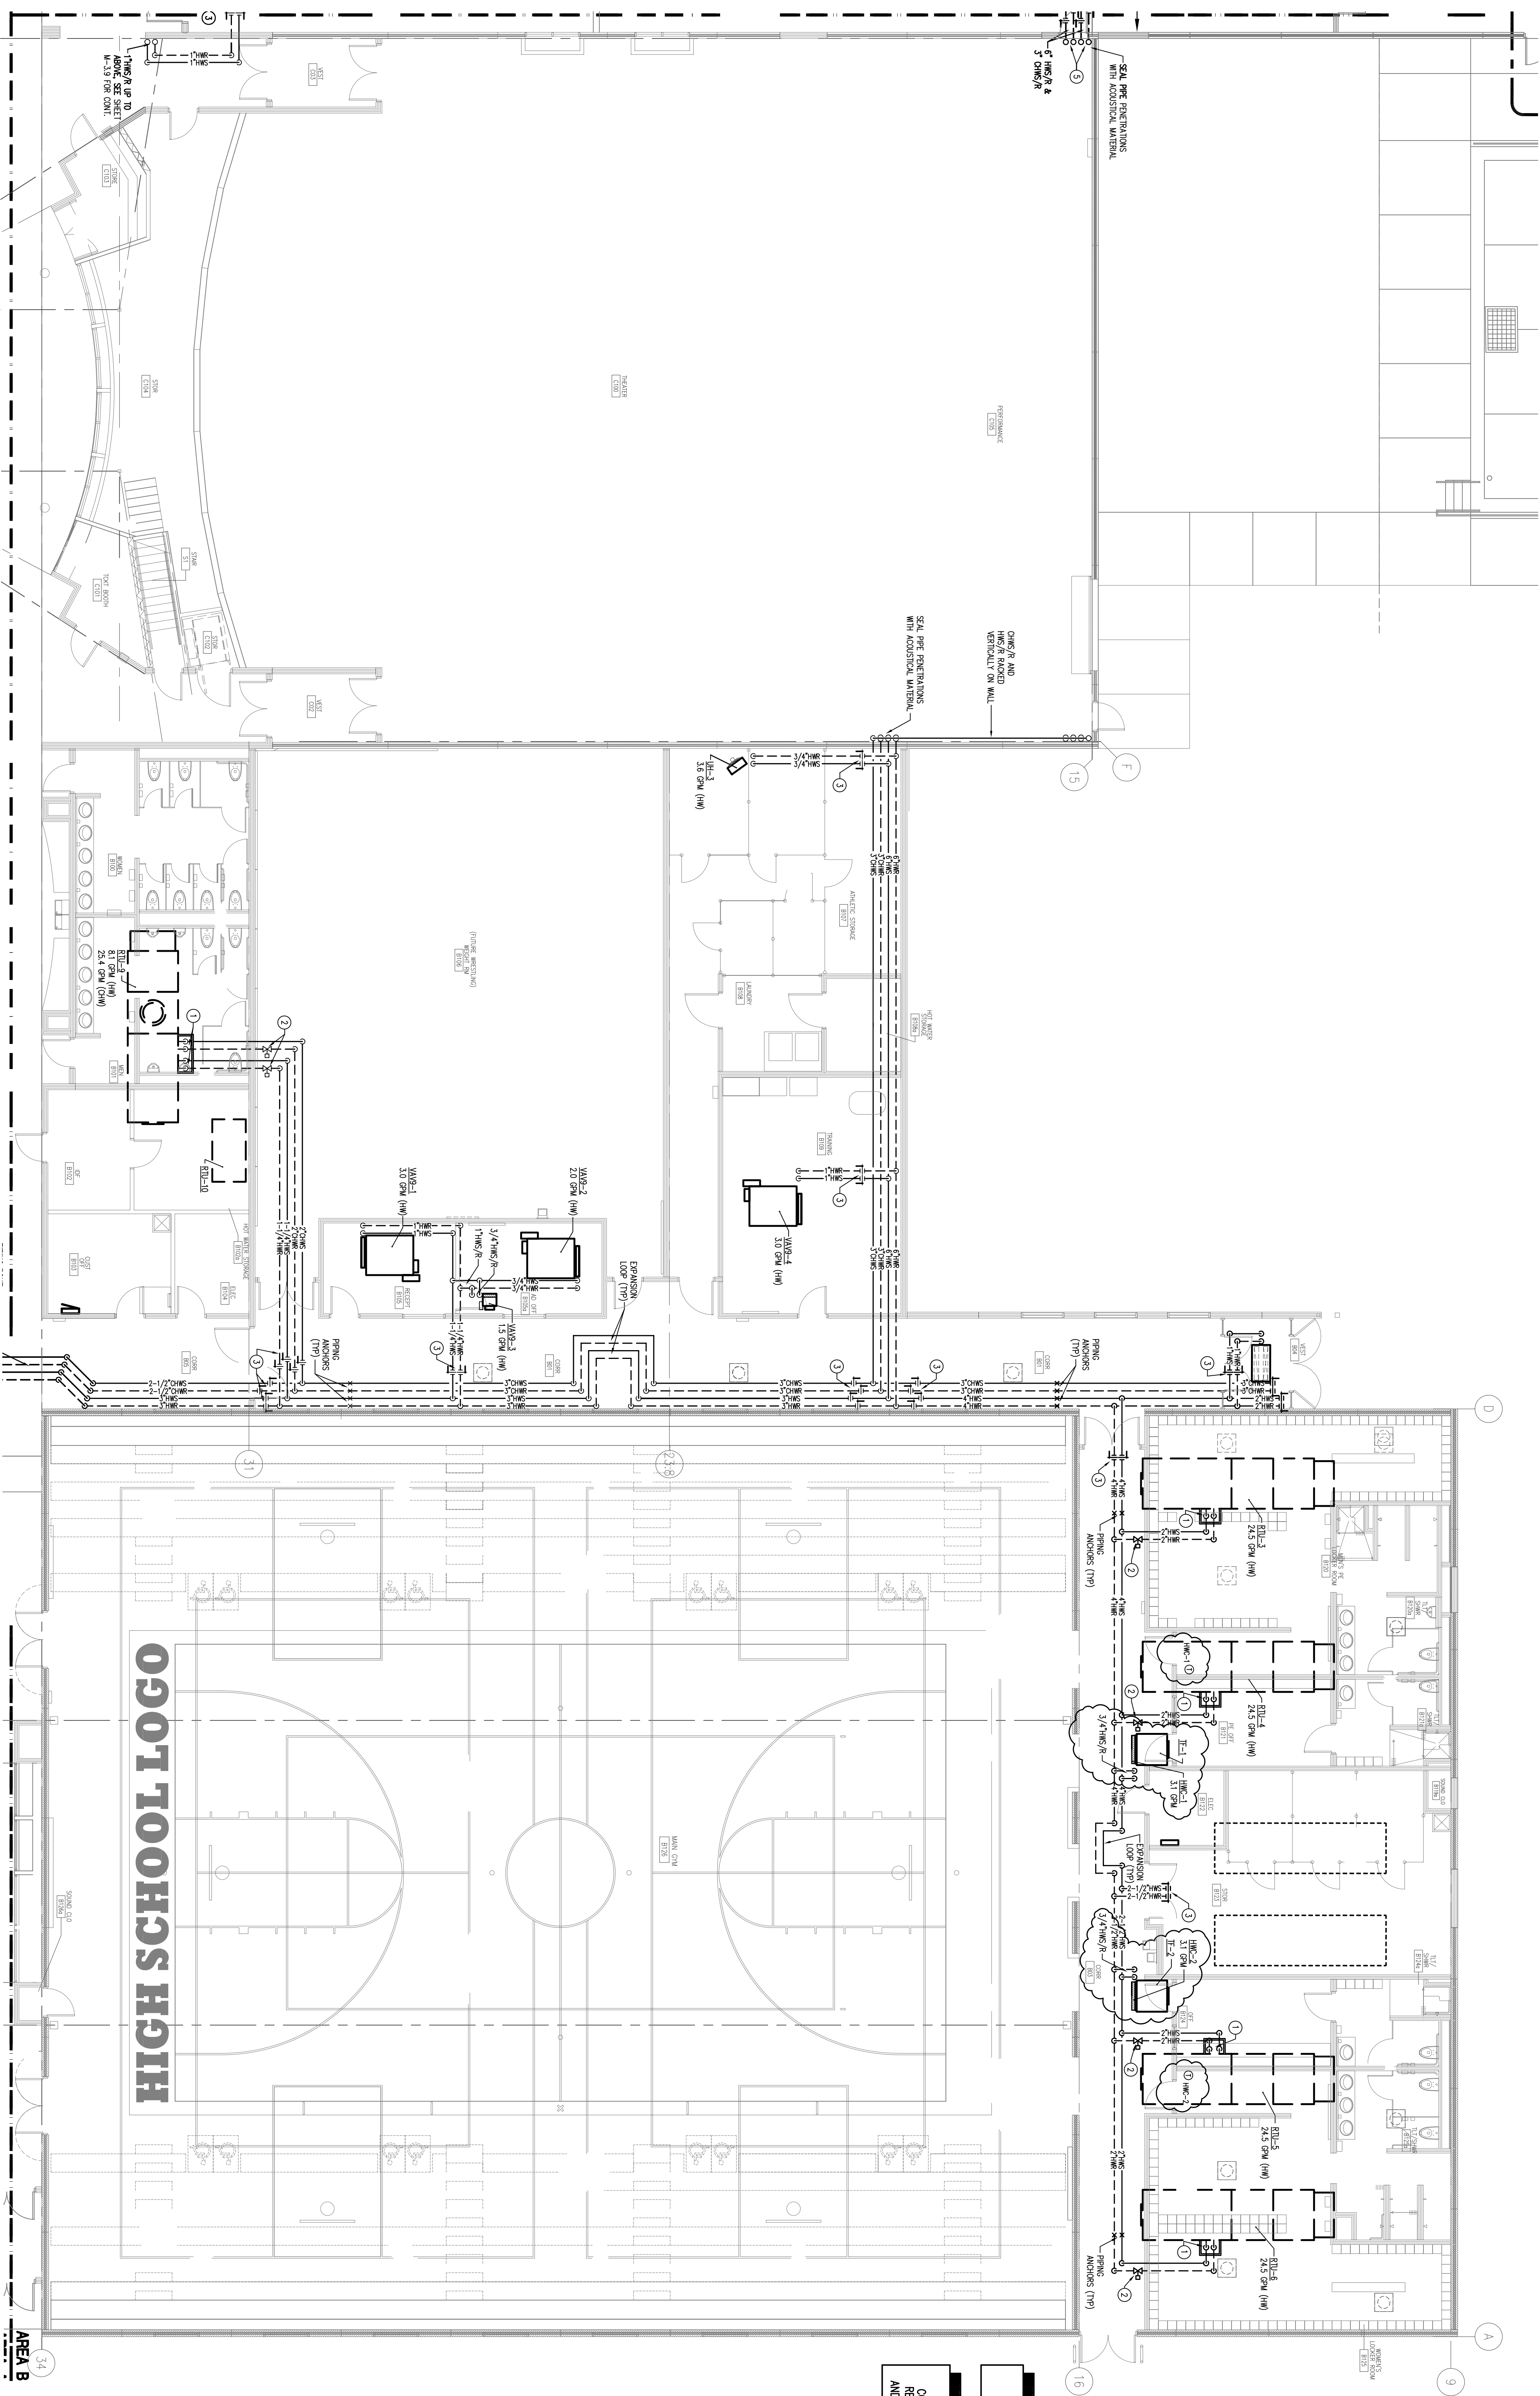

SEE HVAC PLANS FOR
THERMOSTAT LOCATIONS

SEE PLUMBING PLANS FOR
COORDINATION OF RUTS THAT
REQUIRE GAS, MAKE UP WATER
AND DRAINS FOR EVA. SECTIONS

SHEET NOTES

1. HWS & CHWS R/A TO HALLS FROM EXISTING MAIN LEVEL ABOVE TO CEILING AND FLEETED WATER COILS. SEE Piping DETAIL.
2. TEMPERATURE CONTROL VALVE LOCATION IN CEILING SPACE. SEE Piping Schematic.
3. ISOLATION SHUT OFF VALVES. SEE SPECIFICATIONS FOR VALVE RECOMMENDATIONS.
4. HWS & CHWS R/A FROM ABOVE ALONG WALL. PIPING TO PREVENTIVE WALL INTO CEILING SPACE OF WESTING ROOM B173 ADJACENT.
5. 4" HWS & 4" CHWS R/A ALONG WALL TO AS HIGH AS POSSIBLE. SEE SHEET W-319 FOR DETAIL.
6. 3/4" HWS & 3/4" CHWS R/A FROM ABOVE AND DN TO W/ABX SEE SHEET W-319 FOR DETAIL.
7. HWS & CHWS R/A PLACED VERTICALLY WITH SHIP PLUMBING FOR APPROVAL. PIPING TO PREVENTIVE WALL INTO CEILING SPACE OF WESTING ROOM B173 ADJACENT.